




C:\USERS\JCOLS\WPF\ENGINEERING, LLC\CLIENTS - DOCUMENTS\GREENPATH DESIGN\101 S MAIN EVART\DWG\ARCH\WPF-24X36 - DDS TITLE SHEET - SME

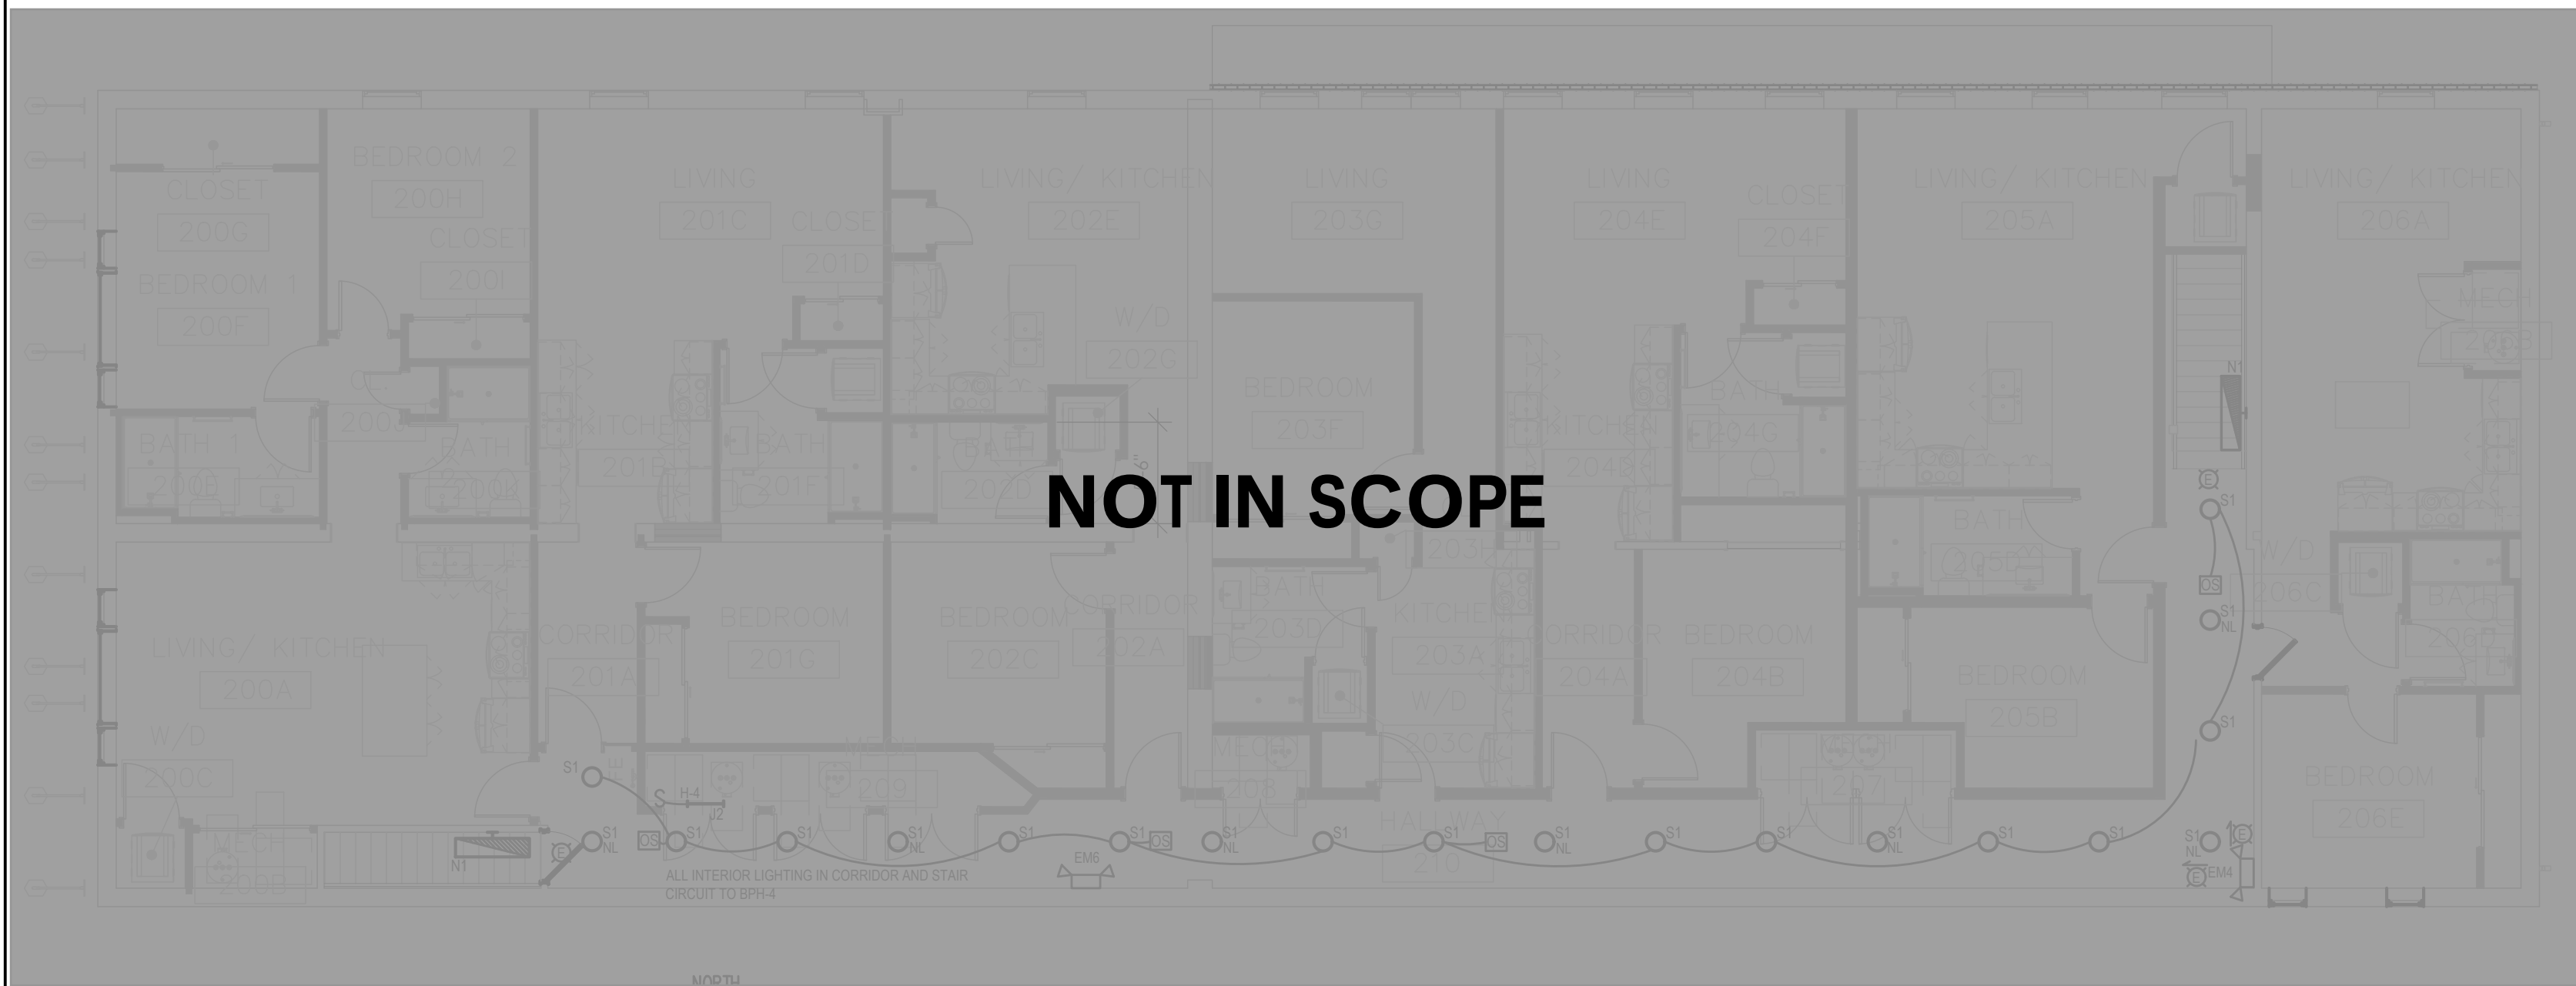

3 LIGHTING PLAN - SECOND FLOOR
SCALE: 1/8" = 1'-0"

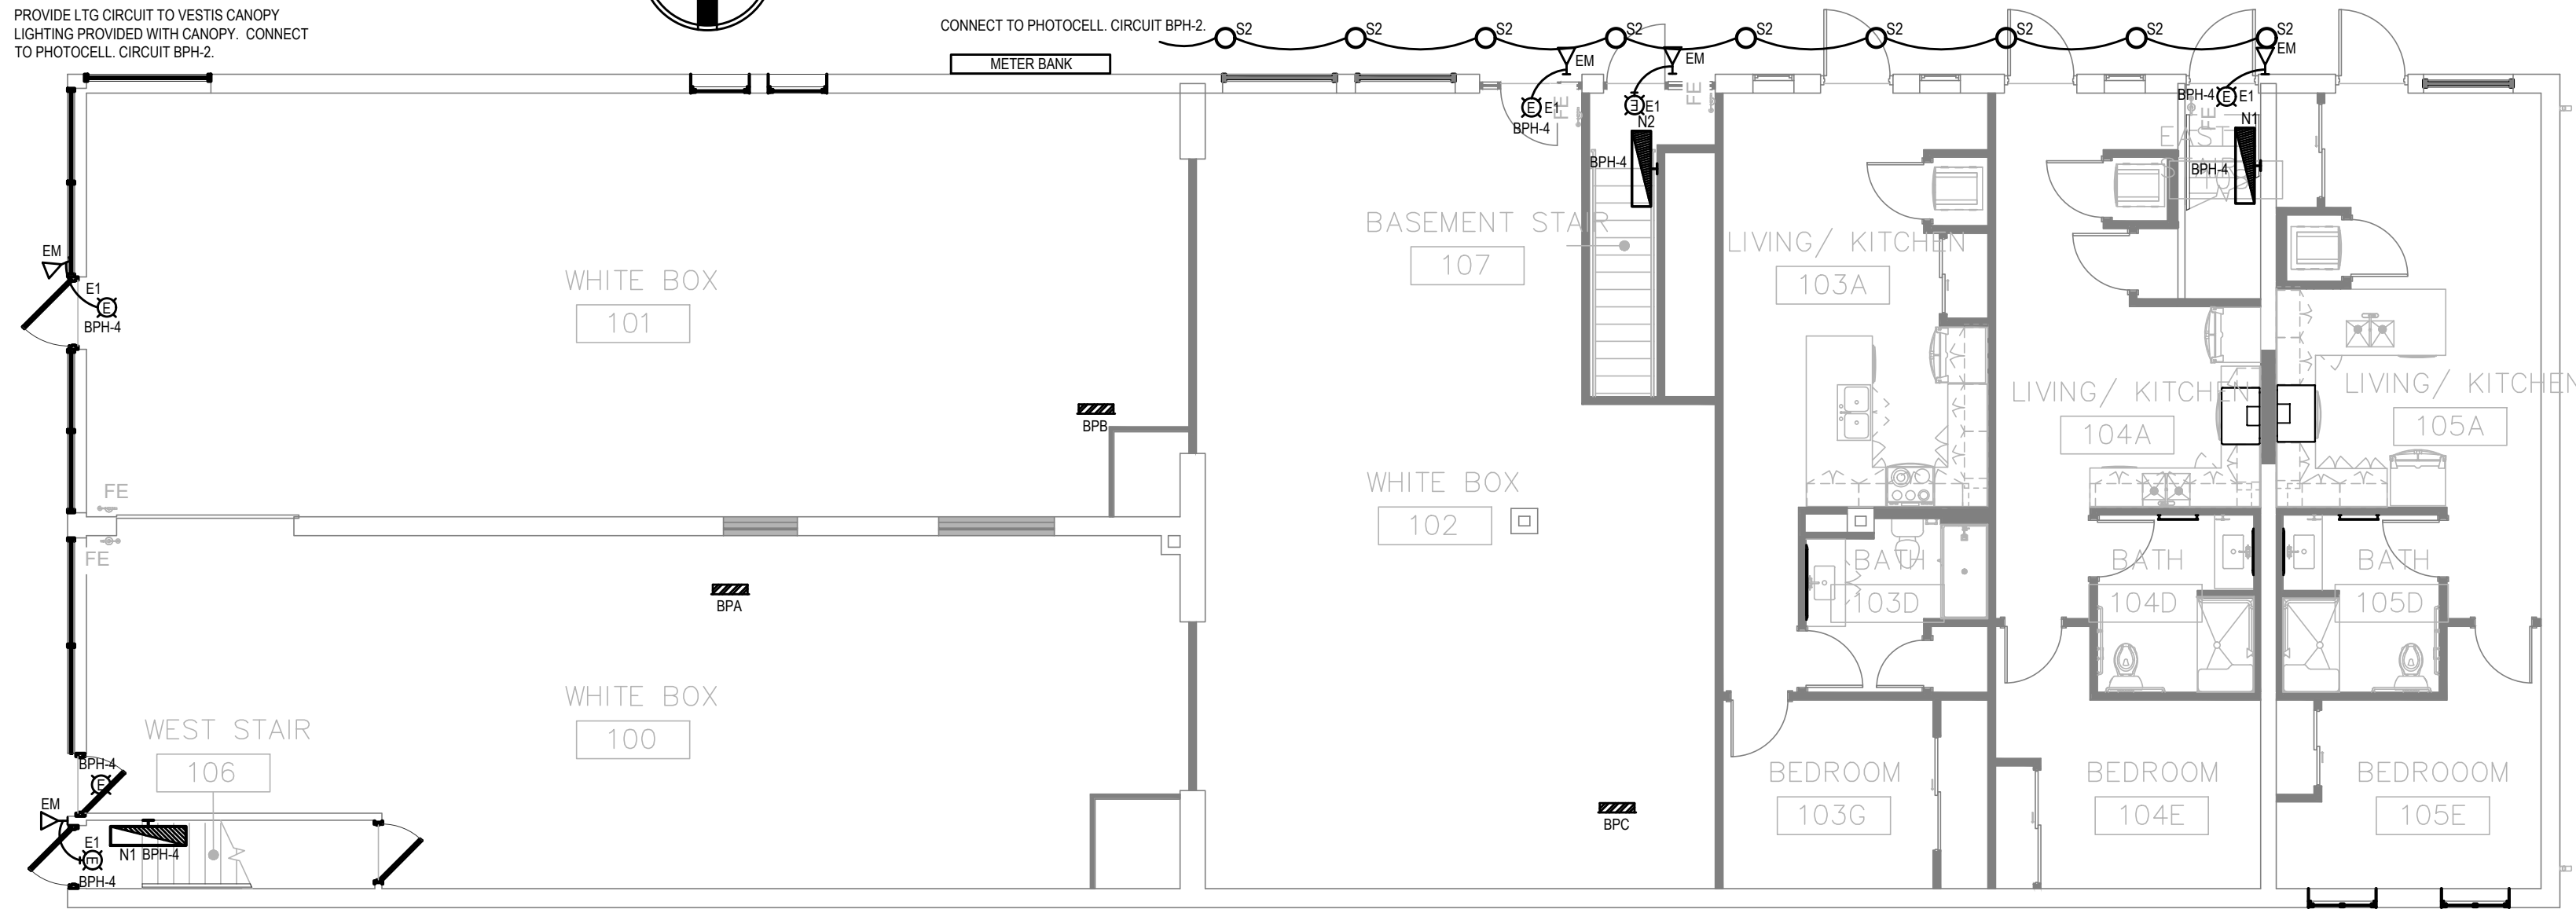

2 LIGHTING PLAN - FIRST FLOOR
SCALE: 1/8" = 1'-0"

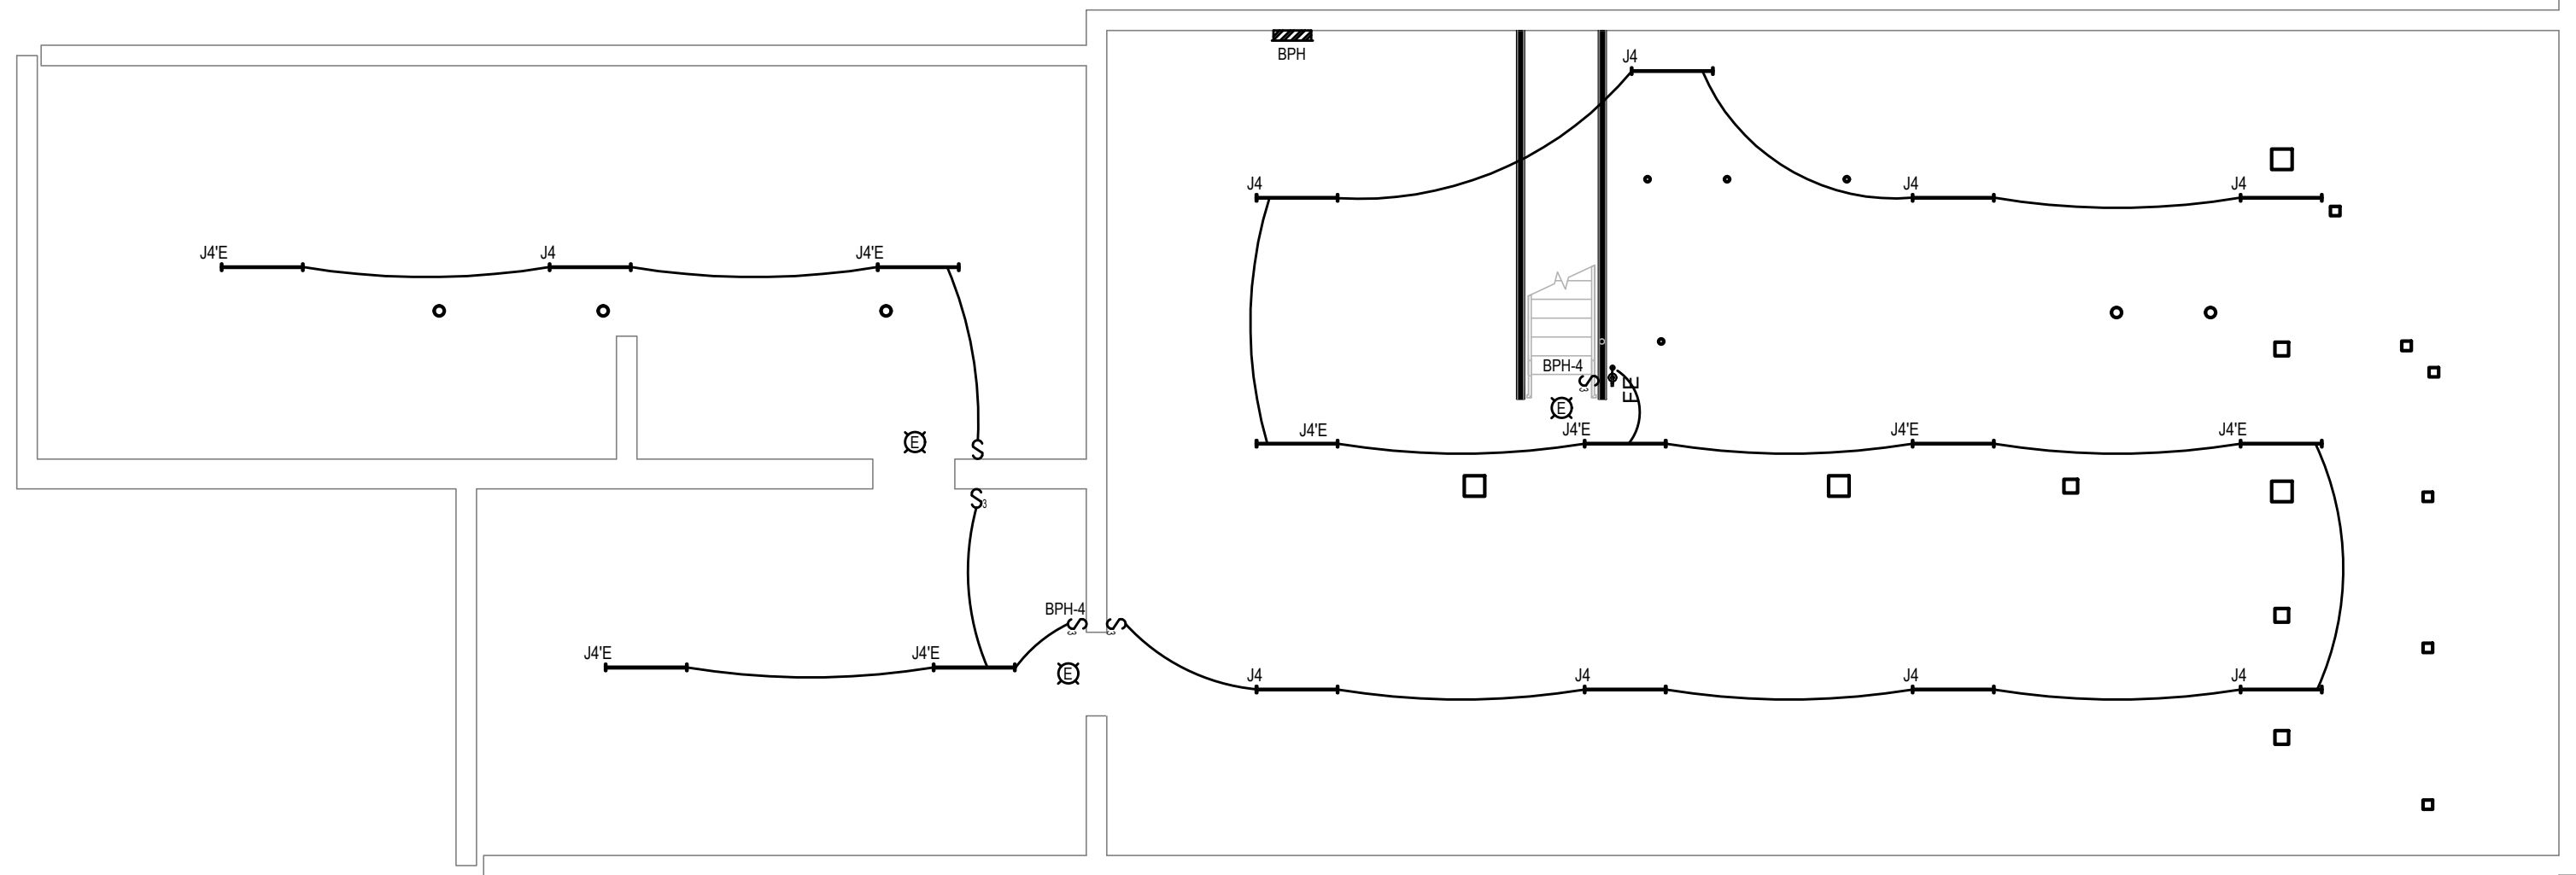

1 LIGHTING PLAN - BASEMENT
SCALE: 1/8" = 1'-0"

GENERAL LIGHTING NOTES

- A. REFER TO ARCHITECTURAL AND ELECTRICAL PLANS, ELEVATIONS AND DETAILS FOR LIGHT FIXTURE MOUNTING HEIGHTS AND LOCATIONS.
- B. E.C. SHALL CONNECT EXIT SIGNS AND EMERGENCY BALLAST/BATTERIES TO UN-SWITCHED LOCAL LIGHTING CIRCUIT.
- C. E.C. SHALL BE RESPONSIBLE FOR PROVIDING FUNCTIONAL TESTING OF LIGHTING CONTROL SYSTEM PER ASHRAE 90.1-2019

LIGHTING PLAN LEGEND

LEGEND SYMBOL INDICATOR

L01 TBD

LIGHT FIXTURE LEGEND

9/11/2025

FIXTURE TYPE	DESCRIPTION	MANU.	CATALOG PART#	FINISH	VOLTAGE	LAMPS	Wattage	REMARKS
CF1	CEILING FAN WITH LIGHT	RP LIGHTING	1071LED-BN-BN-NP CONTROL STATION WC-8 OR EQUAL BY HARBOR BREEZE	BRUSHED NICKEL	120	LED 3000K	23	NO PULL CHAIN FOR LIGHT
E	POLYCARBONATE EXIT SIGN WITH BATTERY	SURE-LITE LITHONIA LSI COMPASS	LPX7 LQMSW3RMVOLT EXRUWBVH SD2 CAR	WHITE	120	LED RED	NA	SELF DIAGNOSTICS BATTERY
E1	POLYCARBONATE EXIT WITH REMOTE HEAD RED/WHITE	LITHONIA DUAL LITE CHLORIDE SURE-LITE	LHQM LED R HORO SD EVCURW-0 VLL CR 2R LPXR8SD		120	LED RED	NA	SELF DIAGNOSTICS BATTERY
EM	LED REMOTE DUAL HEAD WEATHERPROOF	LITHONIA DUAL LITE CHLORIDE SURE-LITE	ELAQWP LO309 SD EVOSW VLL2RGO SRP25BK	GREY	120	LED	NA	MOUNT UP HIGH IN CORNER AS SHOWN DUAL HEAD
EM2	EMERGENCY LIGHT WITH BATTERY	LITHONIA CHLORIDE DUAL-LITE ISOLITE	ELM2L UVOLT LTP SDRT EV2-I BUG-3-WH-SD	WHITE	120	LED	NA	MOUNT 8'-0" AFF. SELF DIAGNOSTICS
EM4	EMERGENCY LIGHT WITH BATTERY	LITHONIA CHLORIDE DUAL-LITE ISOLITE	ELM4L UVOLT LTP SDRT CLU N W EWHC6I BUG-6-WH-SD	WHITE	120	LED	NA	MOUNT 8'-0" AFF. SELF DIAGNOSTICS
EM6	EMERGENCY LIGHT WITH BATTERY	LITHONIA LSI DUAL-LITE ISOLITE	ELM6L-UVOLT-LTP-SDRT HEL EWHC12I BUG-6-WH-SD	WHITE	120	LED	NA	MOUNT 8'-0" AFF. SELF DIAGNOSTICS
J2	2" LED STRIP WITH LENS 2400 LUMEN	LITHONIA COLUMBIA METALUX DAY-BRITE	CSS-L24-2000LM-MVOLT 35K 80CRI MPS435LWCWEU 2SLSTPSC-UNV FSS 2 20L 835 UNV DIM	WHITE	120	LED 3500K	24	MECH/LAUNDRY ROOM - SWIT CHED
J4	4" LED STRIP WITH LENS CHAIN HANG 18" BELOW CLG 4000 LUMENS	LITHONIA COLUMBIA DAY-BRITE METALUX	CLX-L48-4000LM-SEF-RDL CLS4-4040-10V FSS440L840-UNV-DIM J410 ADD LSXR10 4SNLED-LD5-46SL-LN-UNV-L835-CD1-U	WHITE	120	LED 3500K	36	PROVIDE 10W EMERGENCY BALLAST WHERE NOTED
N1	LED STAIRWELL WALL MOUNTED 4000 LUMENS	COLUMBIA LITHONIA DAY-BRITE METALUX	ESL4-40LW-FAW-ED-U-NXOS BLWP4-40L-ADSM-MVOLT-EZ1-LP830-N100-NESPD7- FSS440L830-UNV-DIM LSXR10 4SWLED40SL-LW-UNV-L830-CD1-SVPD3-U	WHITE	120/277	LED 3000K 80CRI	35	WALL MOUNTED 7.5' AFF ON BOARD OCCUPANCY SENSOR 40-50% LIGHT ON ALL TIME PROVIDE 10W EMERGENCY BALLAST
N2	LED STAIRWELL TO BASEMENT WALL MOUNTED 4000 LUMENS	COLUMBIA LITHONIA DAY-BRITE METALUX	ESL4-40LW-FAW-ED-U-NXOS BLWP4-40L-ADSM-MVOLT-EZ1-LP830-N100-NESPD7- FSS440L830-UNV-DIM LSXR10 4SWLED40SL-LW-UNV-L830-CD1-SVPD3-U	WHITE	120/277	LED 3000K 80CRI	35	WALL MOUNTED 7.5' AFF ON BOARD OCCUPANCY SENSOR LIGHT TO BE OFF UNTIL MOTION IS SENSED. PROVIDE 10W EMERGENCY BALLAST
P1	PENDANT OVER BAR OR PENINSULA	RP LIGHTING	4606BN	BRUSHED NICKEL	120	LED 3000K	9	LAMP INCLUDED
S1	SURFACE MOUNT LED HALLWAY/BATH ROOM 900 - 1000 LUMENS WET LIST ED	JUNO HALO LIGHT OLIER JESCO	JSBT 6IN SWW2 90CRI WL MW HLS6 09 930 1E WH S7R930K10 CM405R-M-3090-WH	WHITE	120	LED 3000K	15	
S2	SURFACE MOUNT LED SHOWER 700 LUMEN CANOPY OUT SIDE	JUNO HALO LIGHT OLIER JESCO	JSBT 4IN SWW2 90CRI WL MW HLS4 07 930 1E WH CM405RA-S SW5	WHITE	120	LED 3000K	10	
U1	UNDERCABINET LIGHT 9"-12" LED KIT CHEN	HALO ELITE JUNO AFX	HU11-09-D9SMB EU-LED-12-450L-DIMTR-120-30K-BZ UPLD 9IN SWW4 90CRI BZ T5L2-12RRB	BLACK OR BRONZE	120	LED 3000K	5	SWITCH ON UNDERCABINET LIGHT HARD WIRE UNIT
U2	UNDERCABINET LIGHT 22"-24" LED KIT CHEN	HALO ELITE JUNO AFX	HU11-24-D9SMB EU-LED-24-450L-DIMTR-120-30K-BZ UPLD 22IN SWW4 90CRI BZ T5L2-21RRB	BLACK OR BRONZE	120	LED 3000K	10	SWITCH ON UNDERCABINET LIGHT HARD WIRE UNIT
V1	LED VANITY LIGHT - 24" CENTER ABOVE MIRROR/COUNTER SEE ARCH ELEVATIONS	WAC LIGHTING	WS-77624-30K-BK	BLACK	120	LED 3000K	21	NOTE 2 MOUNT PER ARCH ELEVATIONS


GENERAL LIGHT FIXTURE SCHEDULE NOTES:

1. ALL FIXTURES SHOWN HALF SHADED OR WITH "E" SUFFIX ARE TO BE PROVIDED WITH A BATTERY PACK

C:\Users\Jcol\OneDrive\Documents\GreenPath Design\101 S Main Evart\DWG\ARCH\WPF-24X36 - DDS Title Sheet - SME

ARCHITECT
Driven Design Studio PLLC
11 Carlyle Street
Battle Creek, MI 49017

(269) 753-8040
cody@drivendesignstudio.com

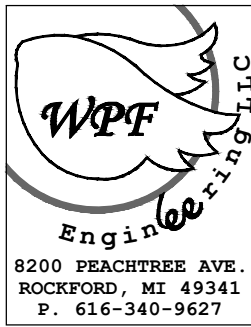

THIS DOCUMENT IS THE EXCLUSIVE
PROPERTY OF DRIVEN DESIGN. THE
DOCUMENT & THE INFORMATION IT
CONTAINS MAY NOT BE REPRODUCED
OR USED FOR OTHER THAN THE
SPECIFIC PROJECT FOR WHICH IT WAS
PREPARED WITHOUT THE EXPLICIT
CONSENT OF DRIVEN DESIGN.

PROJECT NAME
EVART MIXED USE
PROJECT ADDRESS
101 S. MAIN ST. EVART, MI
CLIENT

ISSUE
PERMIT 9/12/2025

REVISION

DRAWN BY LMS
SCALE



9/12/2025
PROJECT NUMBER

Sheet Name

E101