




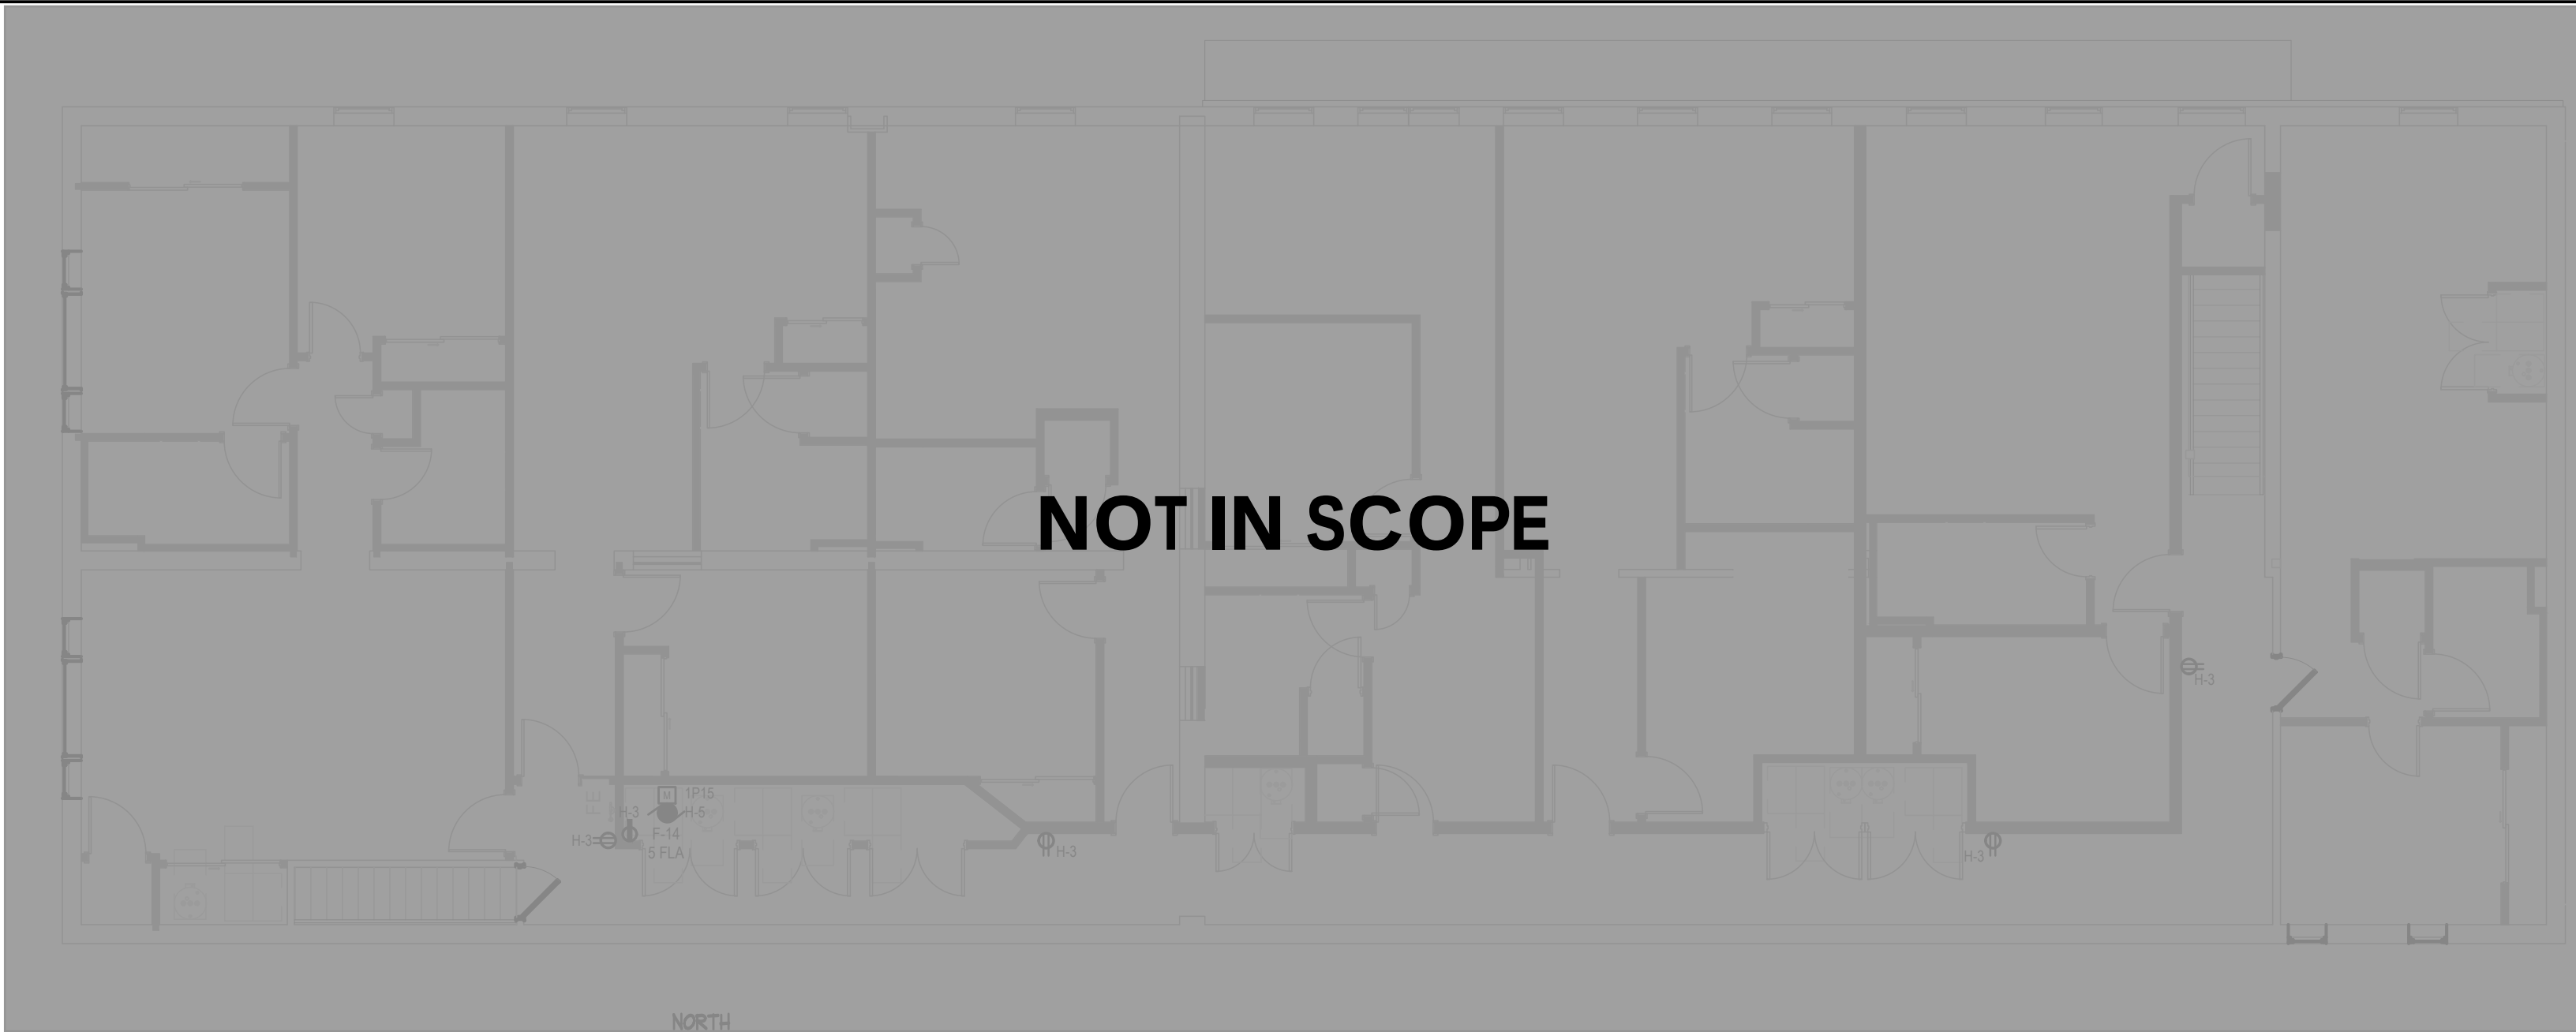

3
E201
POWER PLAN - SECOND FLOOR
SCALE: 1/8" = 1'-0"

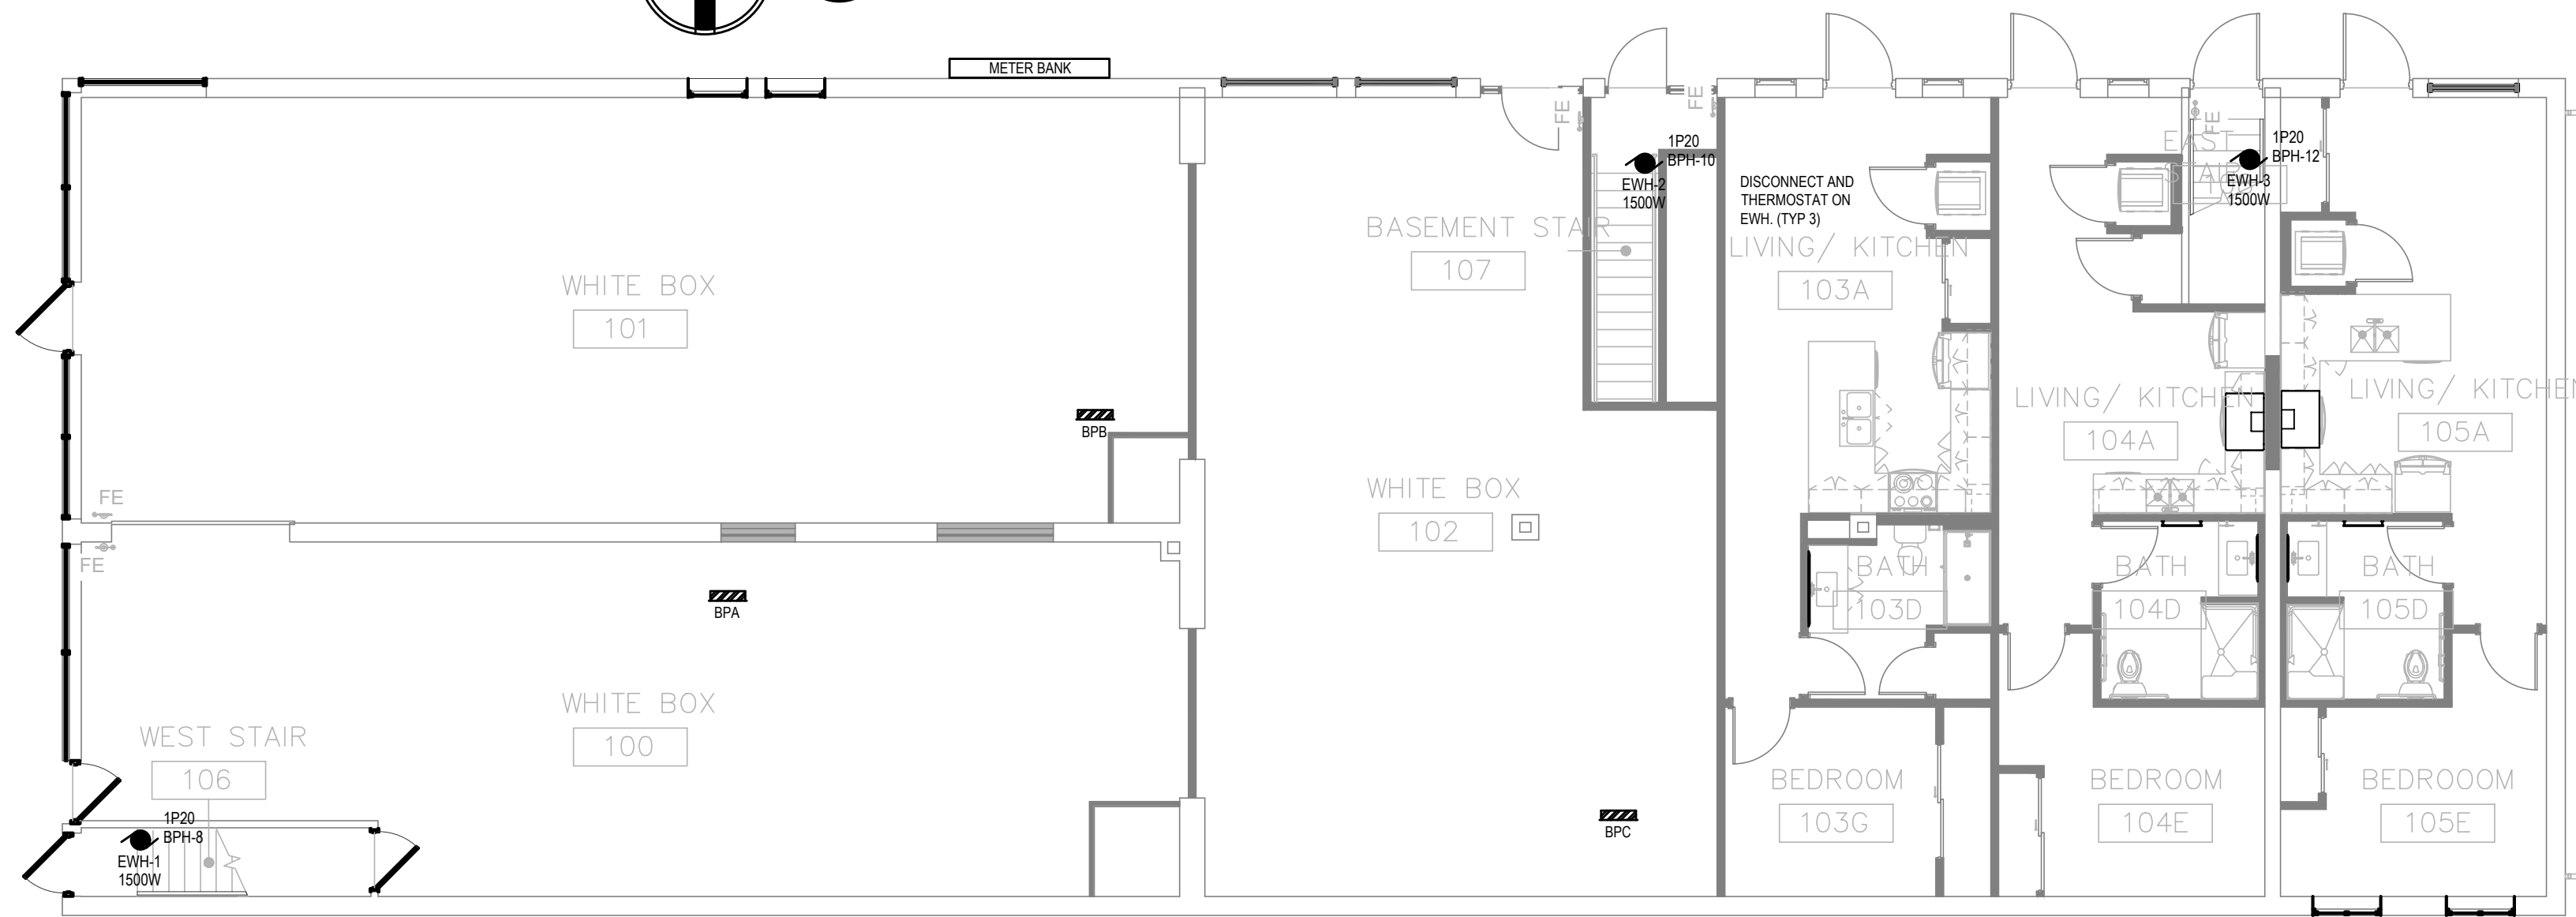

2
E201
POWER PLAN - FIRST FLOOR
SCALE: 1/8" = 1'-0"

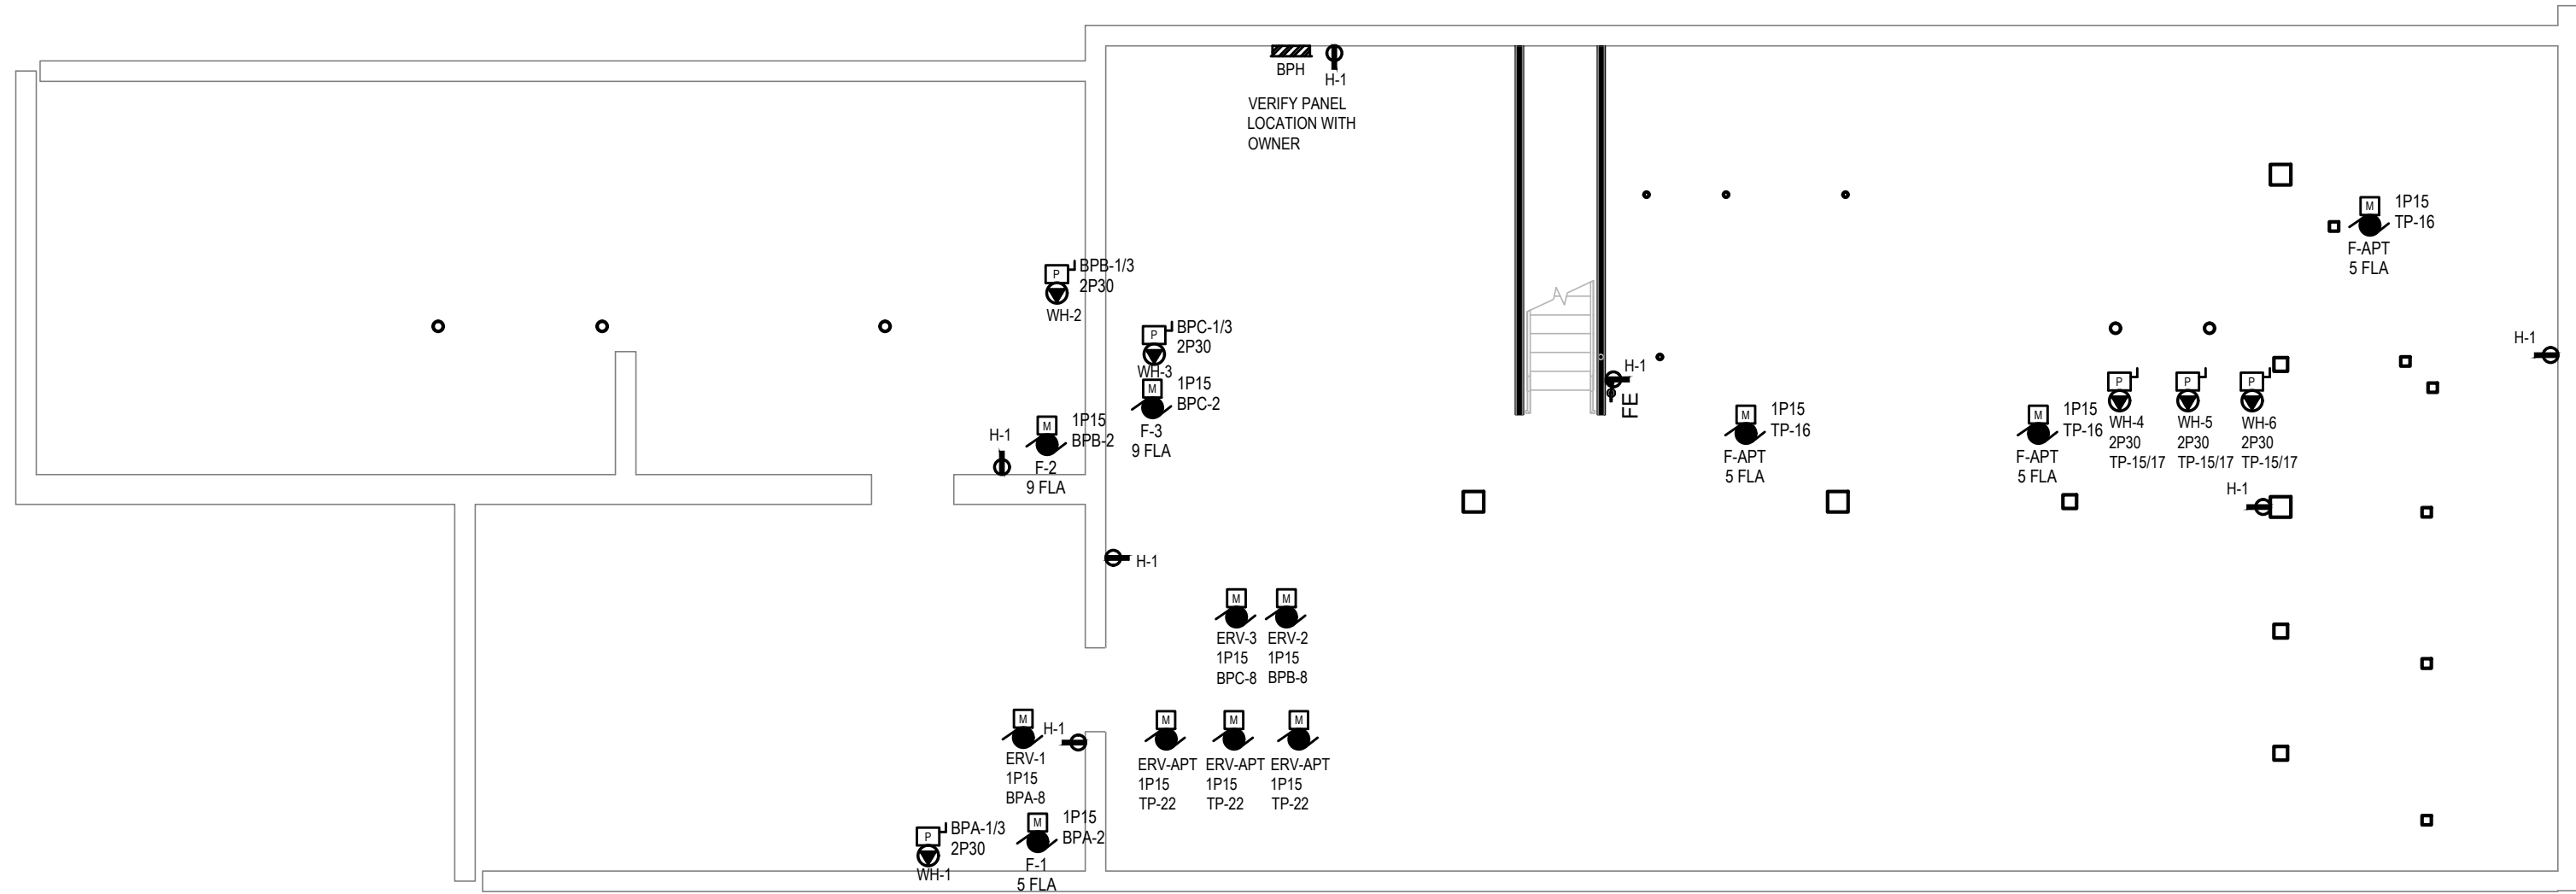

1
E201
POWER PLAN - BASEMENT
SCALE: 1/8" = 1'-0"



PANELBOARD LOADSHEET - 1 PHASE																																							
LTG.				MTRS.				REC.				OTHER								12.08				TOTAL LOAD (KVA)				FILE NO.				PANELS							
1542.00				3880.00				2160.00				4500.00								12.08				TOT. DRV. LOAD (KVA)				DATE				8/6/2025							
1.54				3.88				2.16				4.50																PROJECT #											
																												PHASE				1							
1.00				1.00				Note 1				1.00								58.09				TOT. DIV. AMPS				VOLTAGE				208							
1.54				3.88				2.16				4.50								72.61				TOT. DIV. AMPS X 1.25				CIRCUIT CAPACITY				30							
																												MAIN BREAKER/LUGS				100							
																												MOUNTING				SURFACE							
																																TVSS:							
																																200% NEUTRAL:							
																								</															