



C:\USERS\JCOLLS\WPF\ENGINEERING, LLC\CLIENTS - DOCUMENTS\GREENPATH DESIGN\101 S MAIN EVART\DWG\ARCH\WPF-24X36 - DDS TITLE SHEET - SWE



POWER PLAN - SECOND FLOOR
E201
SCALE: 1/8" = 1'-0"

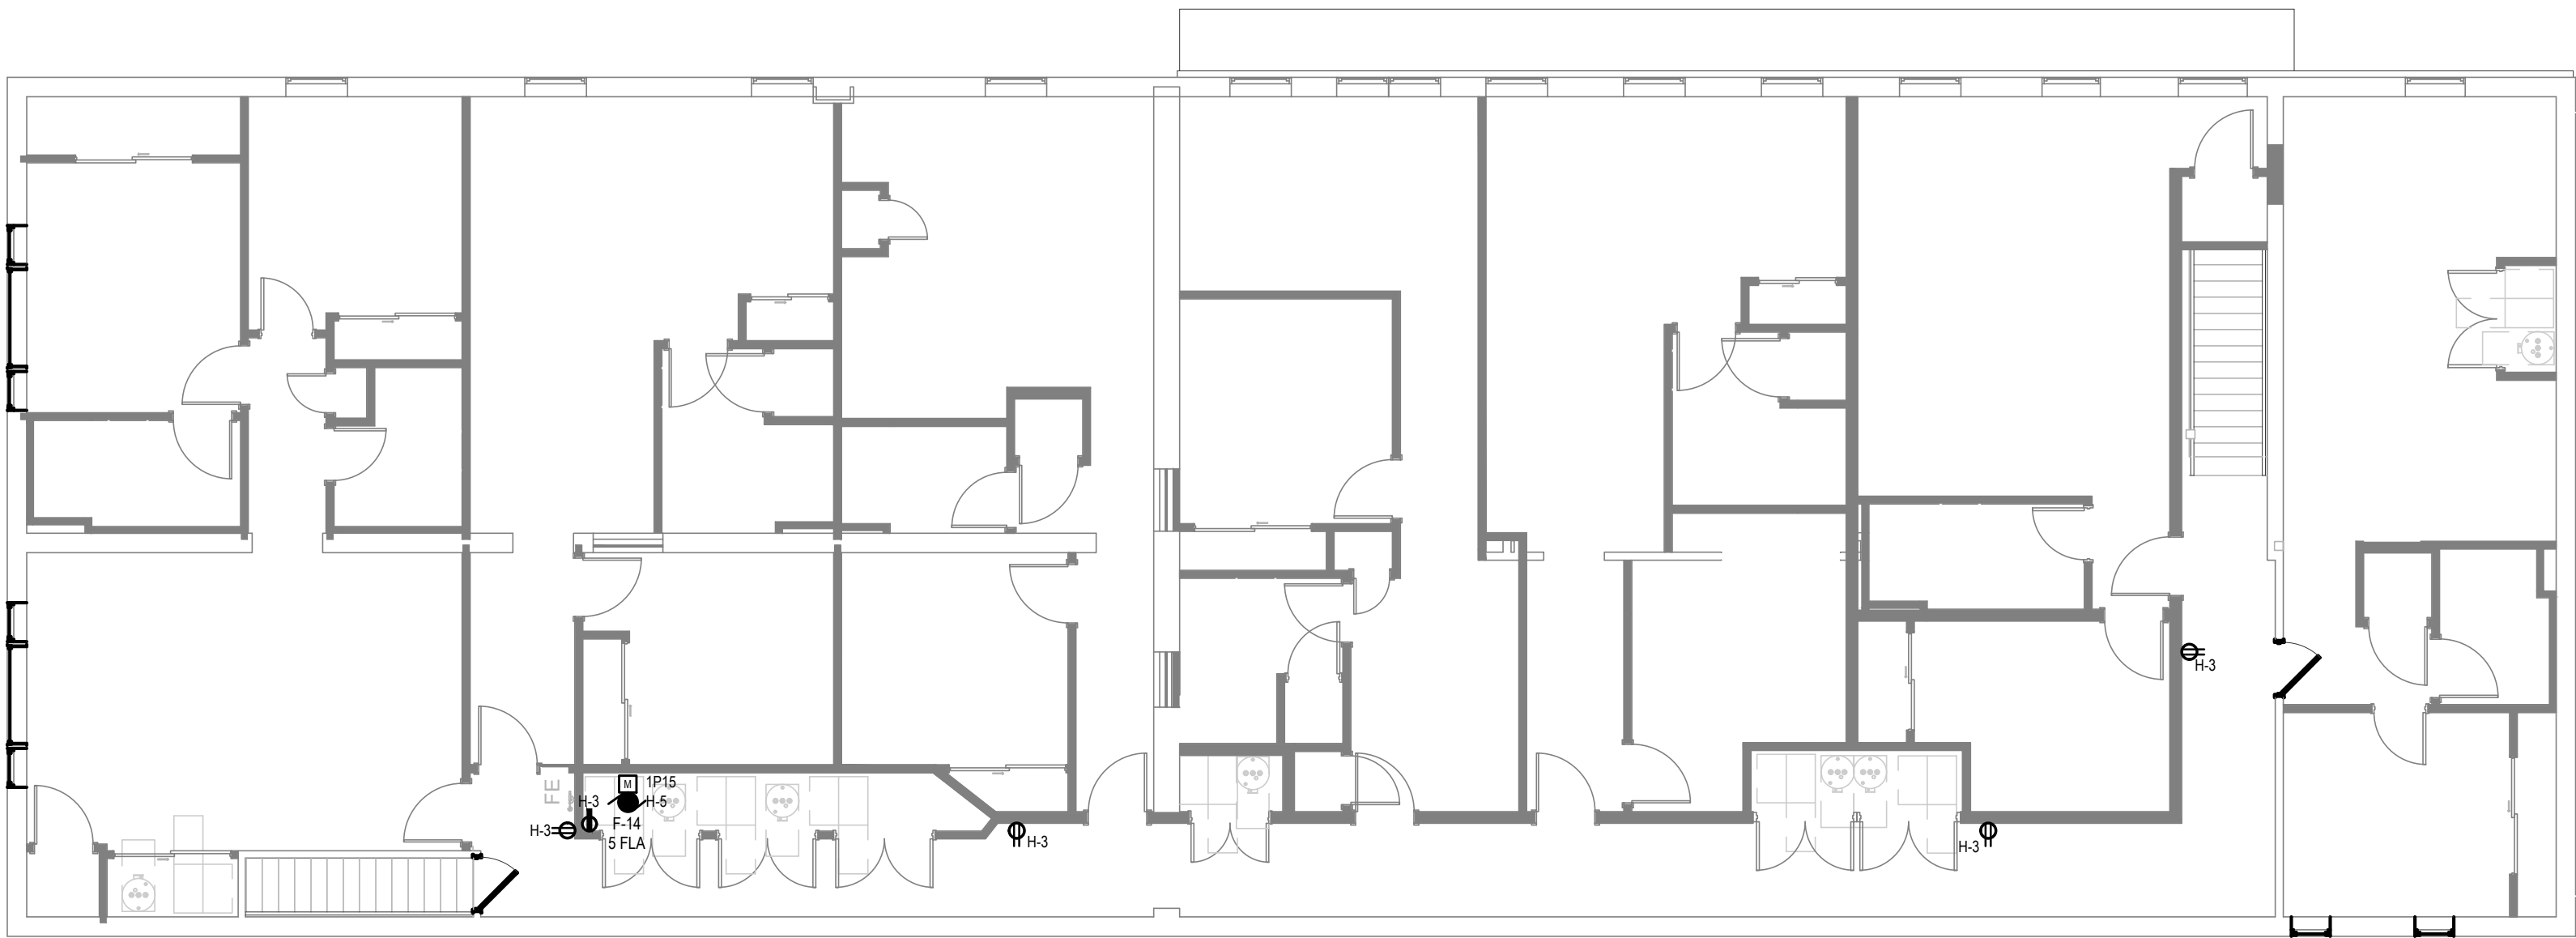

POWER PLAN - FIRST FLOOR
E201
SCALE: 1/8" = 1'-0"

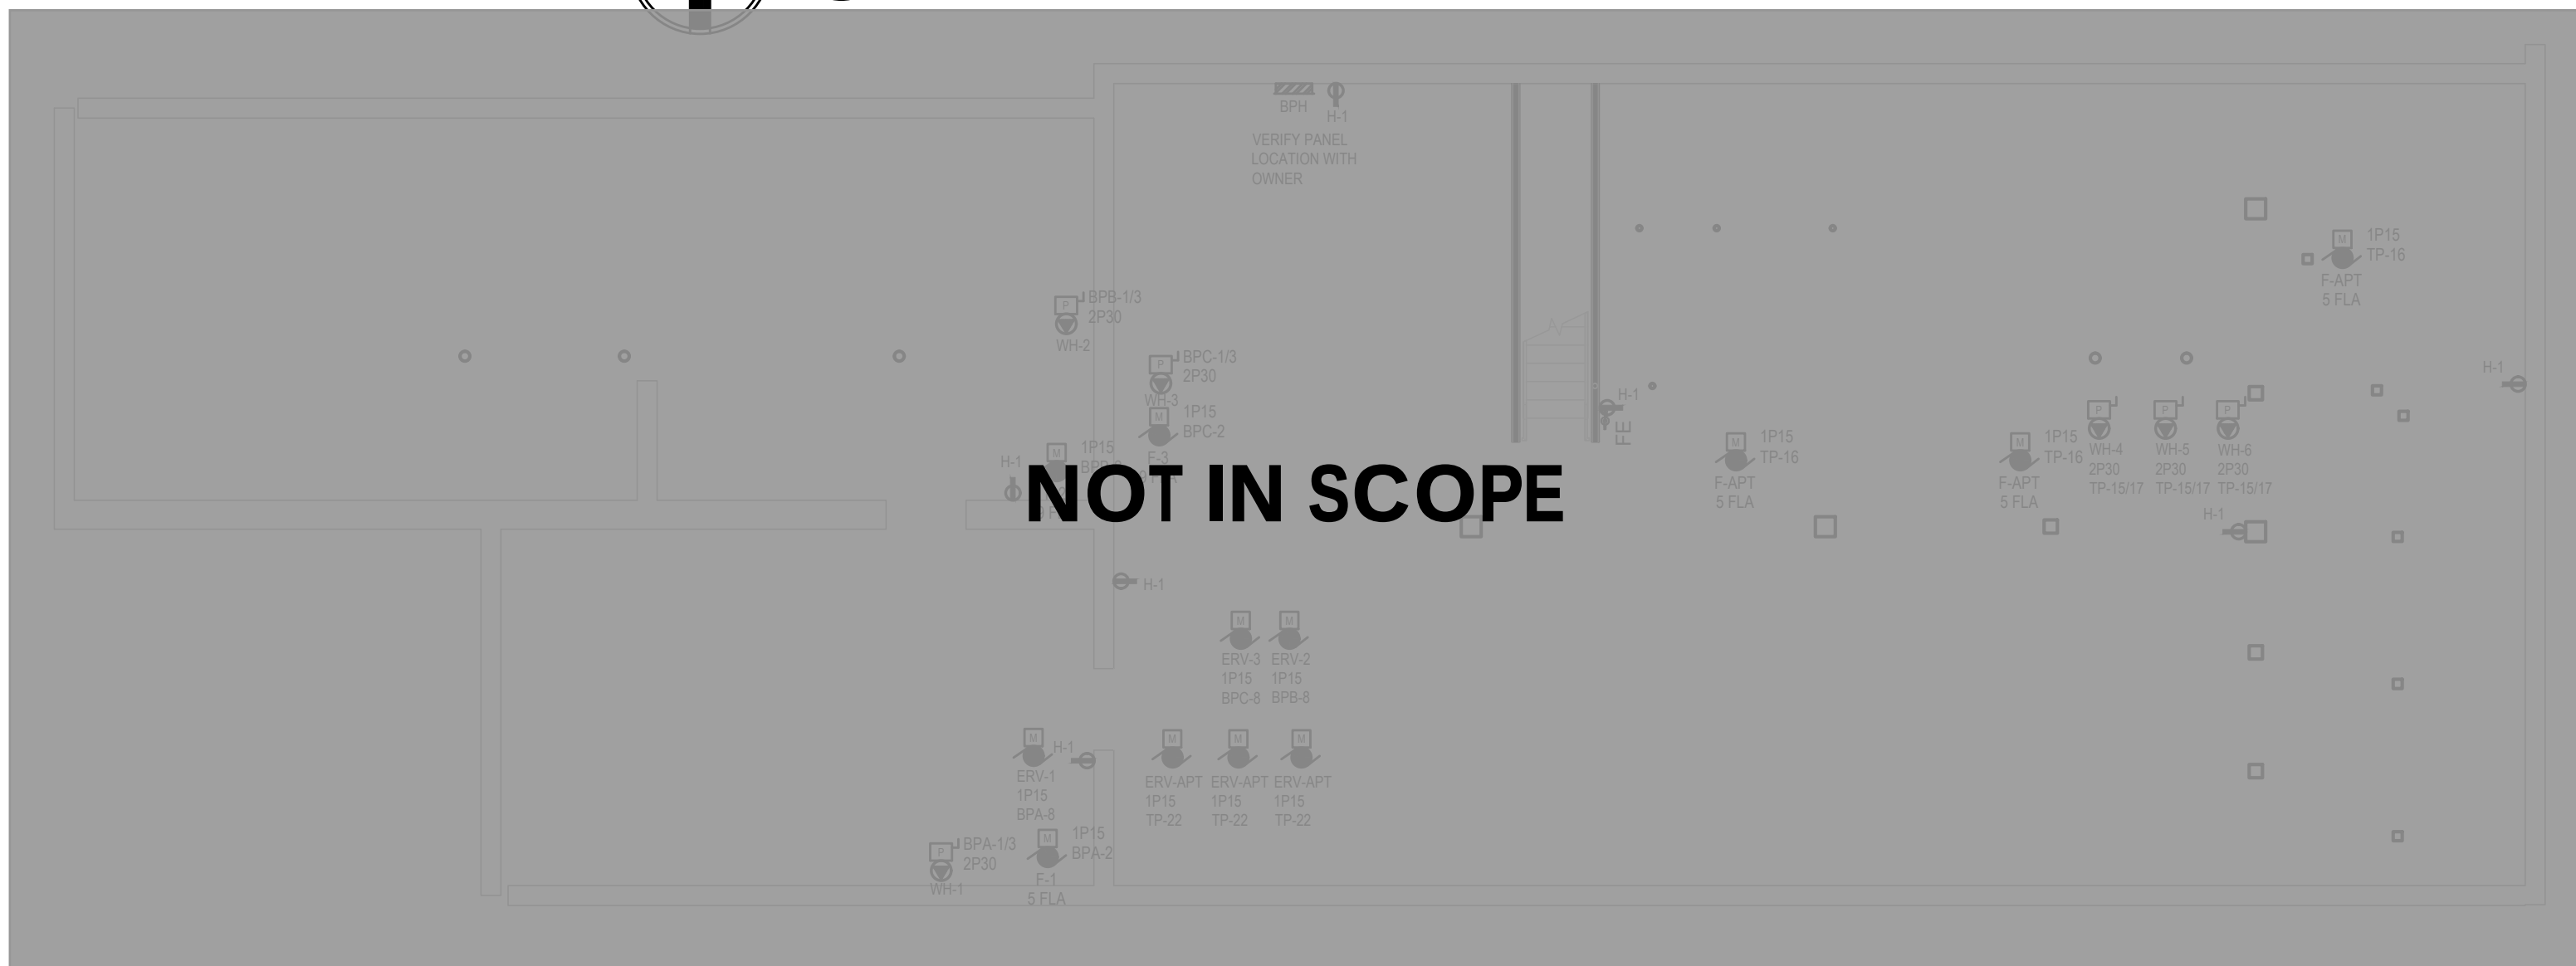

POWER PLAN - BASEMENT
E201
SCALE: 1/8" = 1'-0"

PANELBOARD LOADSHEET - 1 PHASE																
										FILE NO. DATE		PANELS 8/6/2025				
LTG.					MTRS.					REC.					OTHER	
1542.00					3880.00					2160.00					4500.00	
1.54					3.88					2.16					4.50	
1.00					1.00					Note 1					1.00	
1.54					3.88					2.16					4.50	
										LOAD (VA)						
										LOAD (KVA)						
										DIVERSITY						
										DIVERSIFIED LOAD (KVA)						
										58.09					TOT. DIV. AMPS	
										72.61					TOT. DIV. AMPS X 1.25	
										MAIN BREAKER/LUGS					VOLTS	
										MOUNTING					POLES	
										TVSS:					M.L.O.	
										200% NEUTRAL:					SURFACE	